


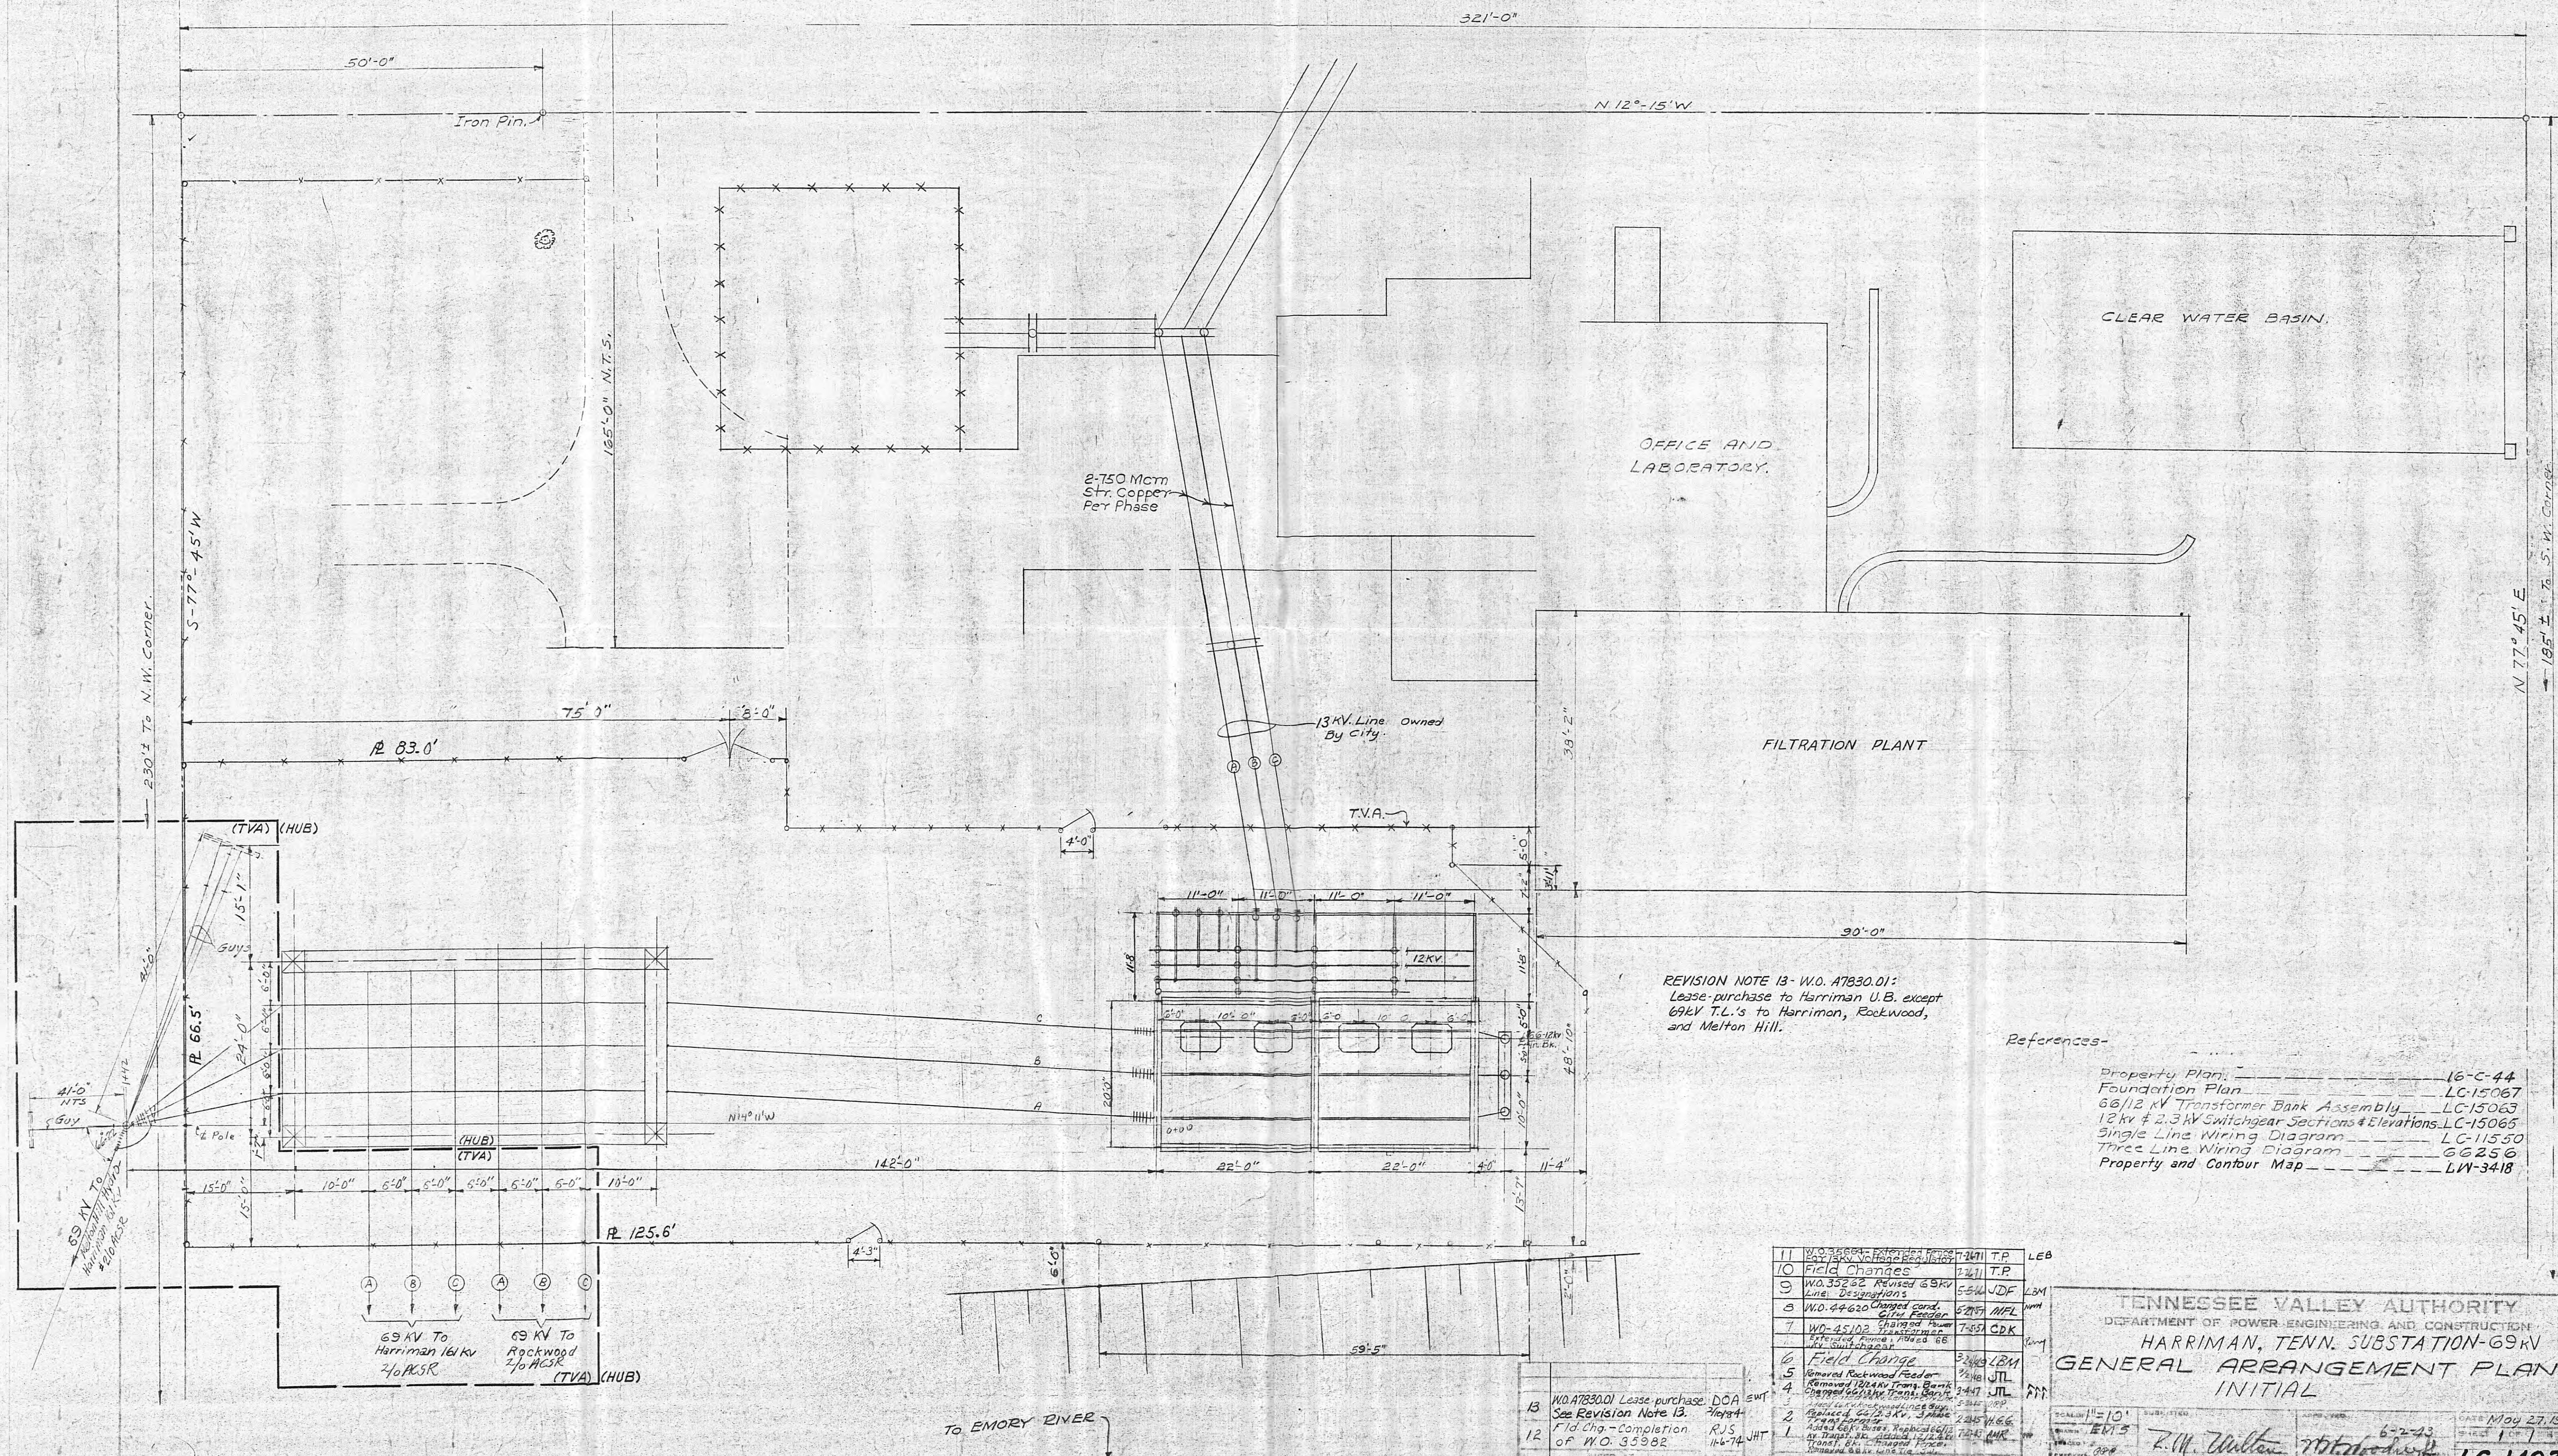

References-

Property Plan	16-C-44
Foundation Plan	LC-15067
66/12 KV Transformer Bank Assembly	LC-15063
1 KV & 2.3 KV Switchgear Sections & Elevations	LC-15065
Single Line Wiring Diagram	LC-11550
Three Line Wiring Diagram	GG256
Property and Contour Map	LW-3418

[illegible]

F Z K M P 	LHM north long 11 22 	TENNESSEE VALLEY AUTHORITY DEPARTMENT OF POWER-ENGINEERING AND CONSTRUCTION HARRIMAN, TENN. SUBSTATION-69kV GENERAL ARRANGEMENT PLAN. INITIAL			
11 22 	11 22 	SCALE 1"=10' DRAWN EHS CHECKED RPB APPROVED 	SUBMITTED R.H. Wiltan 	APPROVED 6-2-53 Wiltan AHN	DATE May 27, 1943 SHEET 1 OF 7 SHEETS LC-14924 R-13